




1 SECTION THROUGH TOP ALLEY
SCALE: 1" = 1'-0"

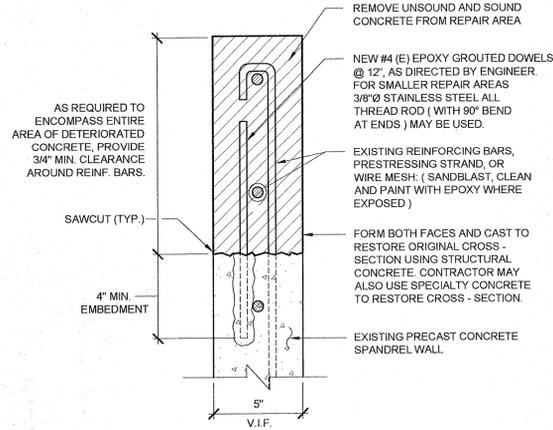


2 TOP OF WALL CONCRETE REPAIR
SCALE: N.T.S.

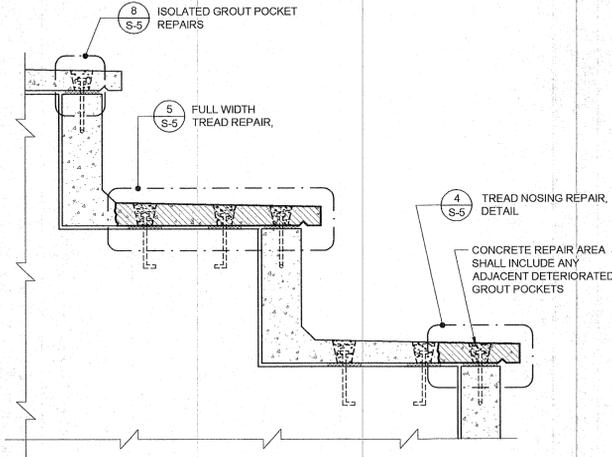


3 SECTION THROUGH TREAD AND RISER
SCALE: 1" = 1'-0"

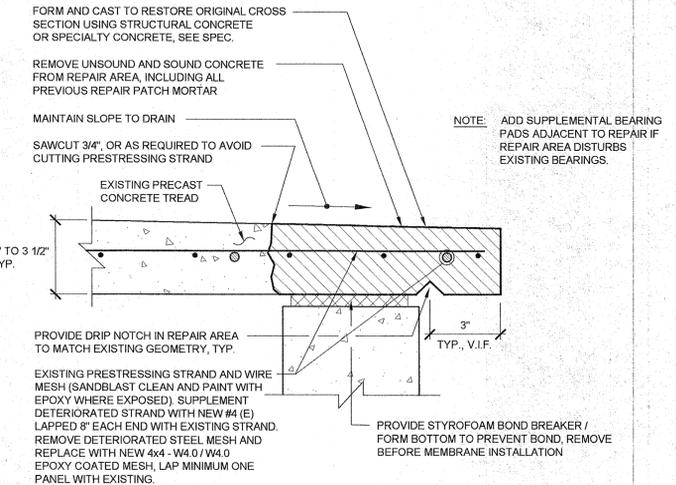


4 PRECAST TREAD NOSING REPAIR DETAIL
SCALE: N.T.S.

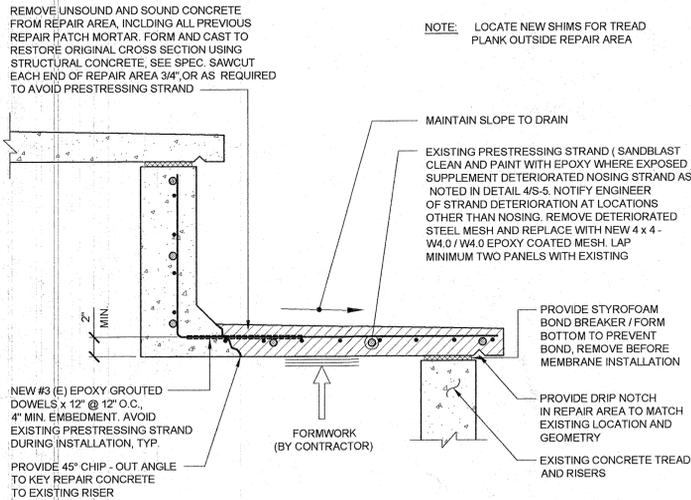


5 FULL WIDTH TREAD REPAIR DETAIL
SCALE: N.T.S.

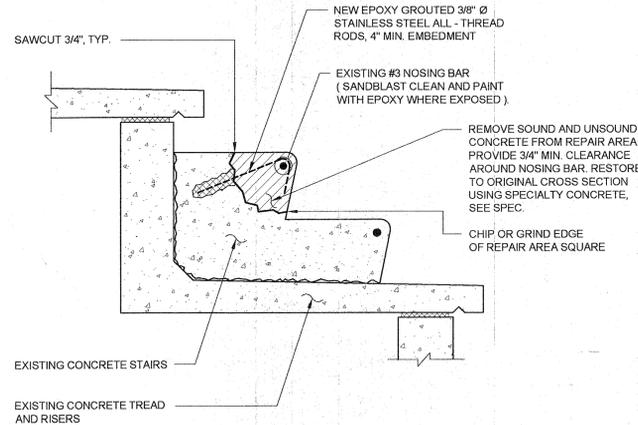


6 AISLE STAIR REPAIR DETAIL
SCALE: 1" = 1'-0"

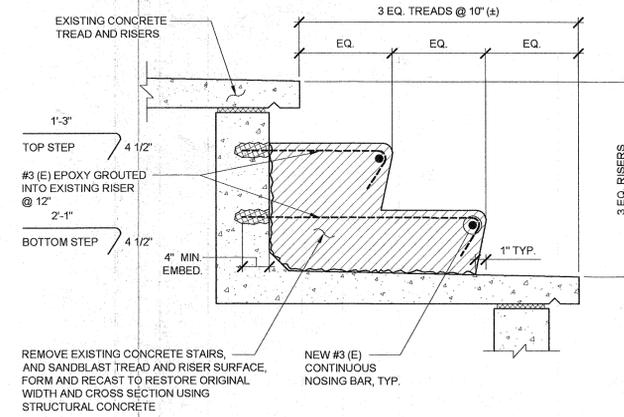


7 AISLE STAIR REPAIR DETAIL
SCALE: 1" = 1'-0"

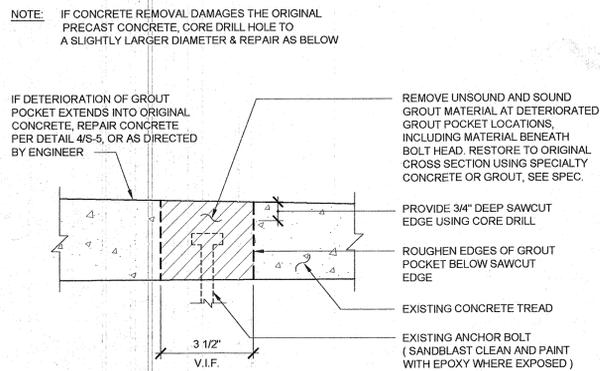


8 GROUT POCKET REPAIR DETAIL
SCALE: N.T.S.

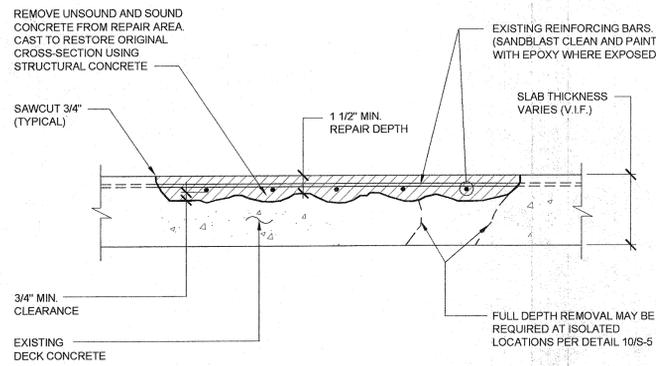

9 TYPICAL PARTIAL DEPTH CONCRETE REPAIR
SCALE: N.T.S.

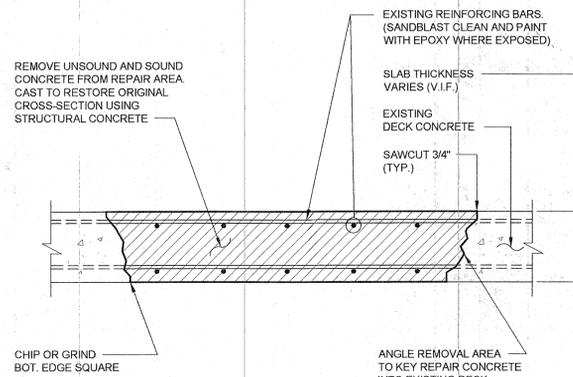

10 TYPICAL FLAT SLAB FULL-DEPTH CONCRETE REPAIR
SCALE: N.T.S.

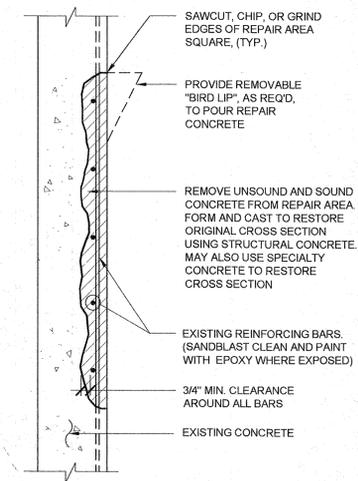

11 TYPICAL CONCRETE REPAIRS AT VERTICAL SURFACES
SCALE: N.T.S.

HUTCHINSON SMITH ARCHITECTS
ENGINEERS ARCHITECTS MATERIALS SCIENTISTS

WJE

BOISE STATE UNIVERSITY
STADIUM STRUCTURAL REPAIRS
1190 UNIVERSITY DRIVE
BOISE, IDAHO 83725

Date: 29 AUGUST 2005
DPW No: 05209
DRAWN BY: RHS
Check: NSA/DDC
FILE NAME:
REV:

PROFESSIONAL ENGINEER REGISTERED
W. J. Nugent
8/29/05
WILLIAM J. NUGENT
STATE OF IDAHO

LICENSED ARCHITECT AR-1577
8-29-05
ROBERT L. SMITH
STATE OF IDAHO

SHEET TITLE: CONCRETE REPAIR DETAILS

DRAWING **S-5**